


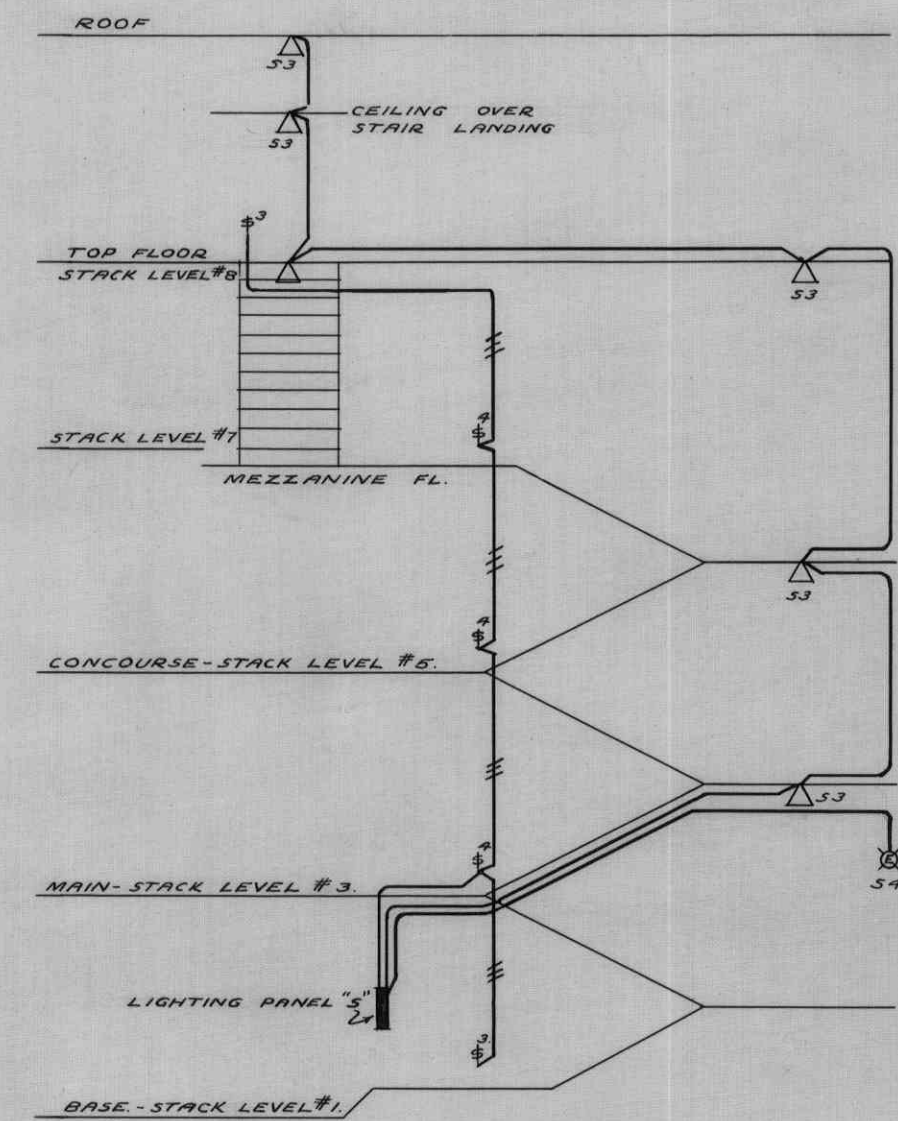


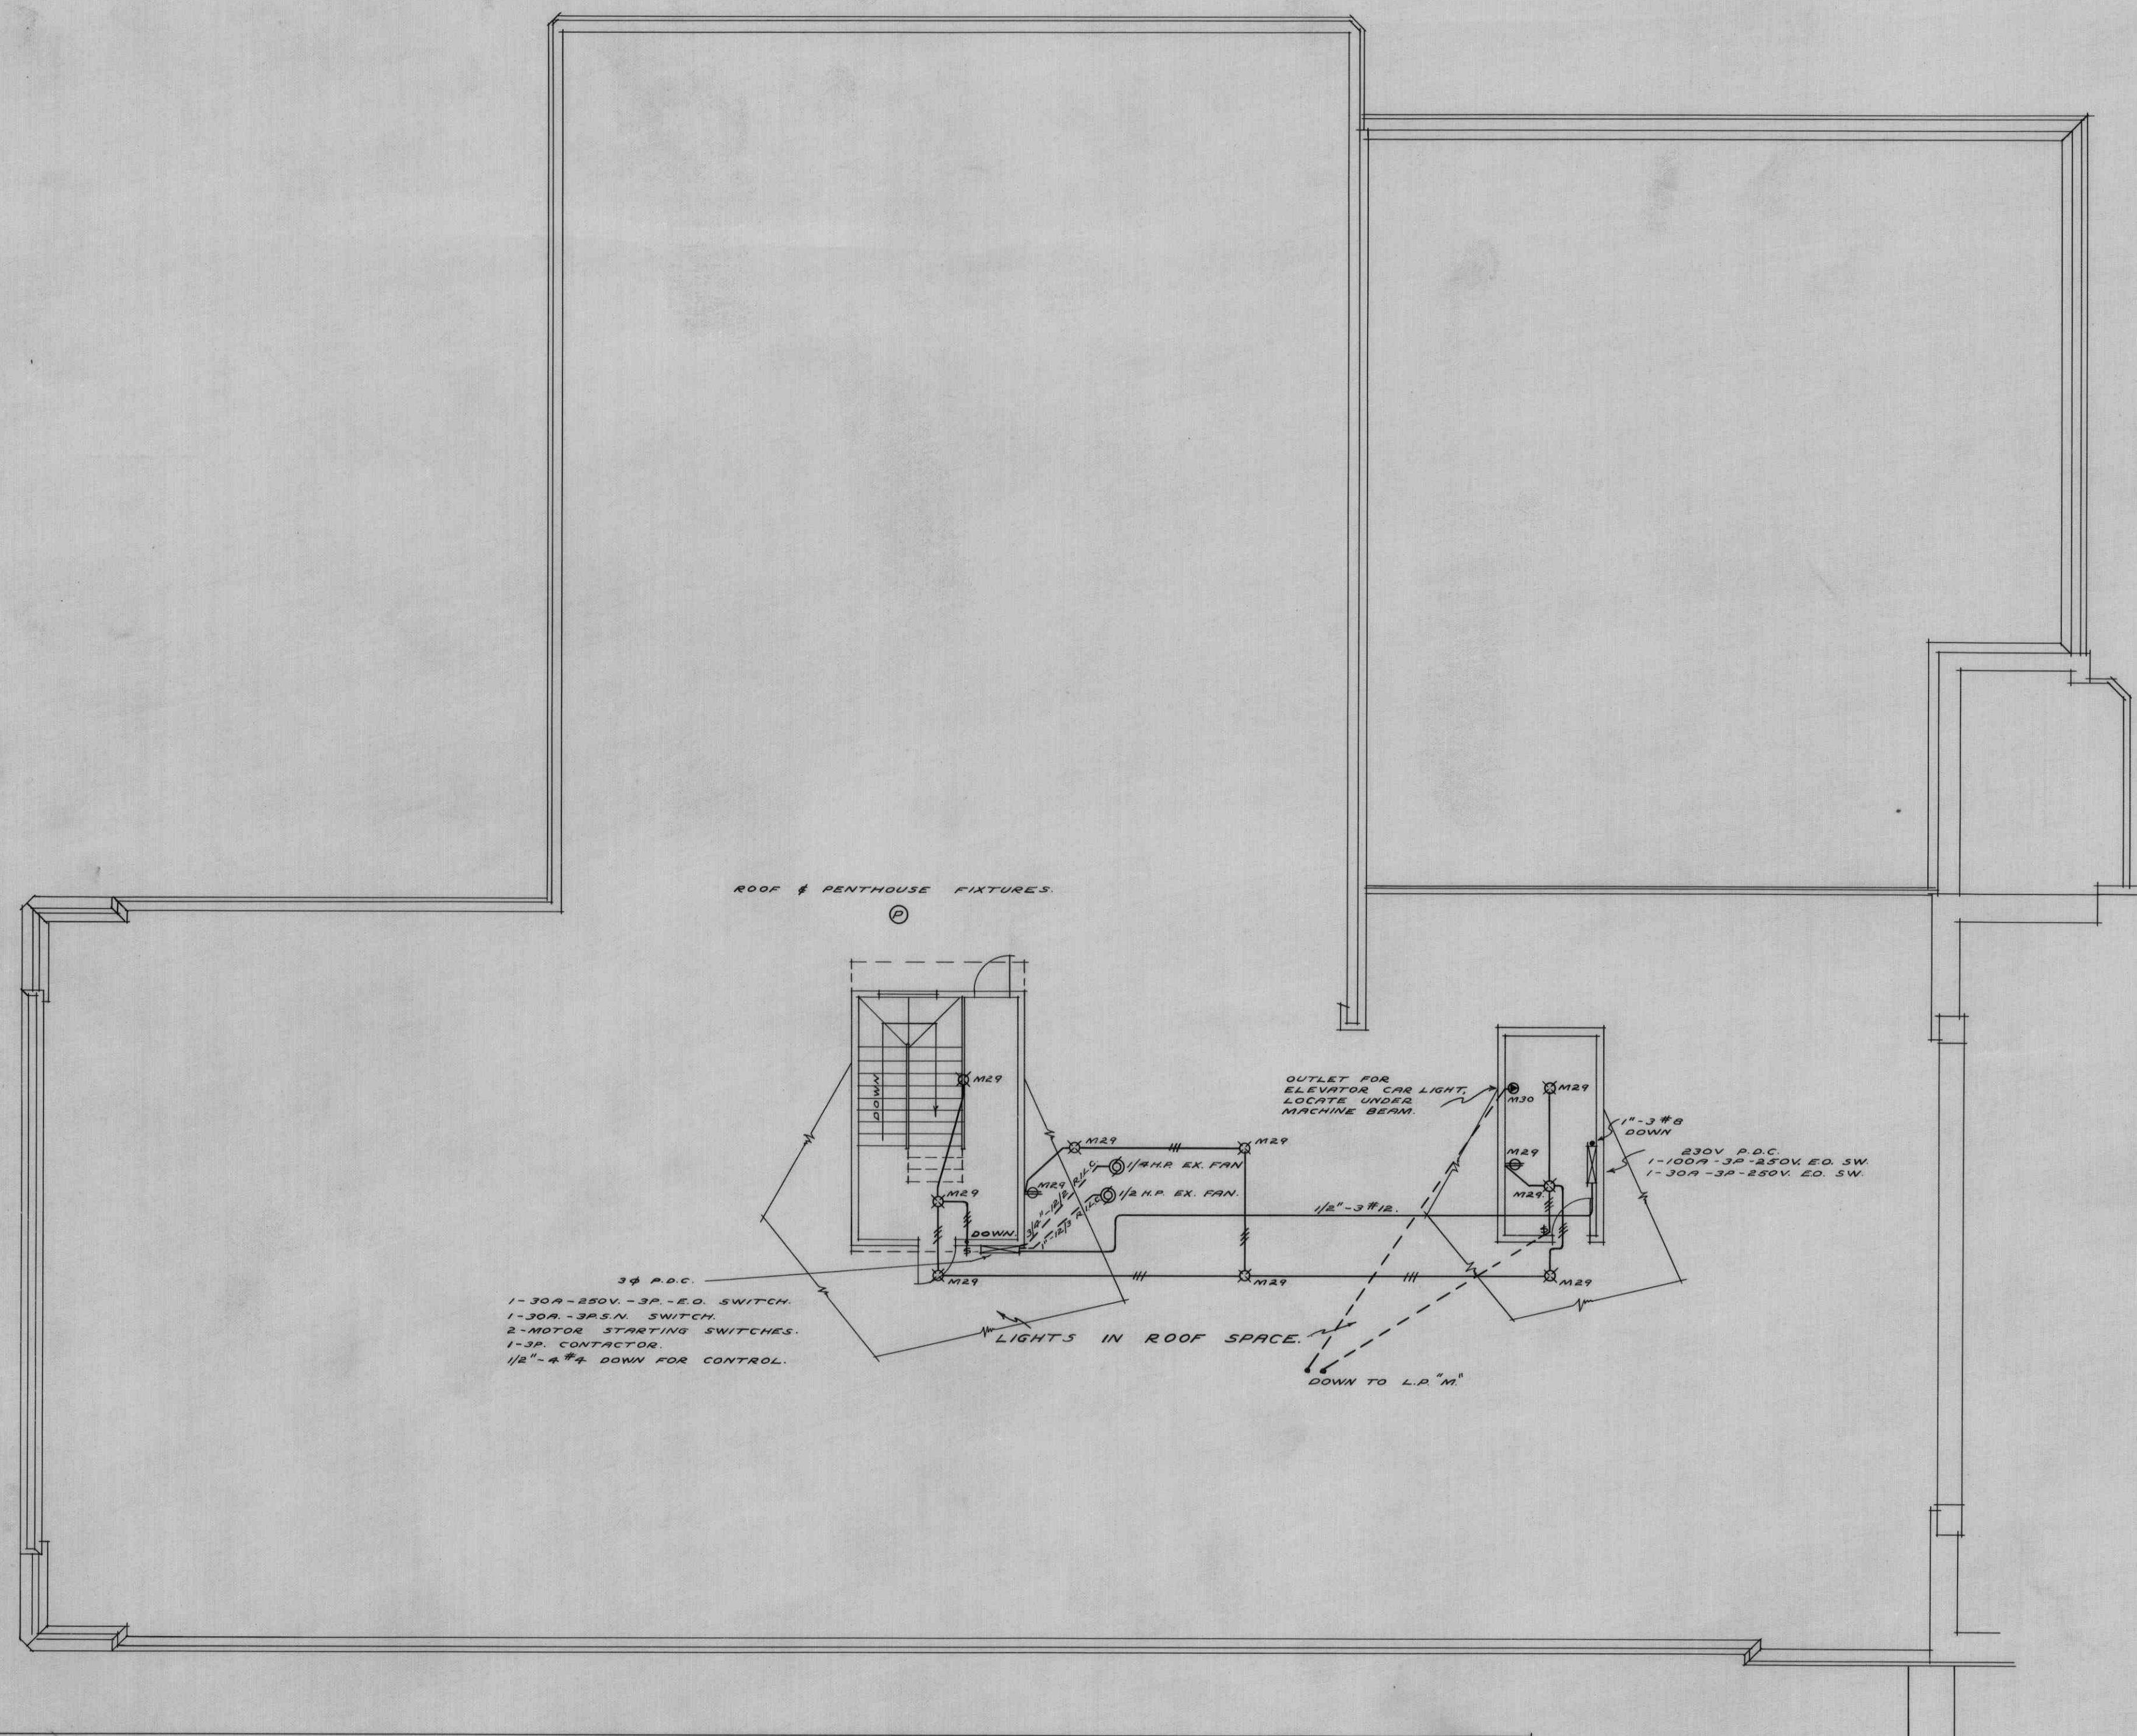

STAIR RISER DIAGRAM
NOT TO SCALE

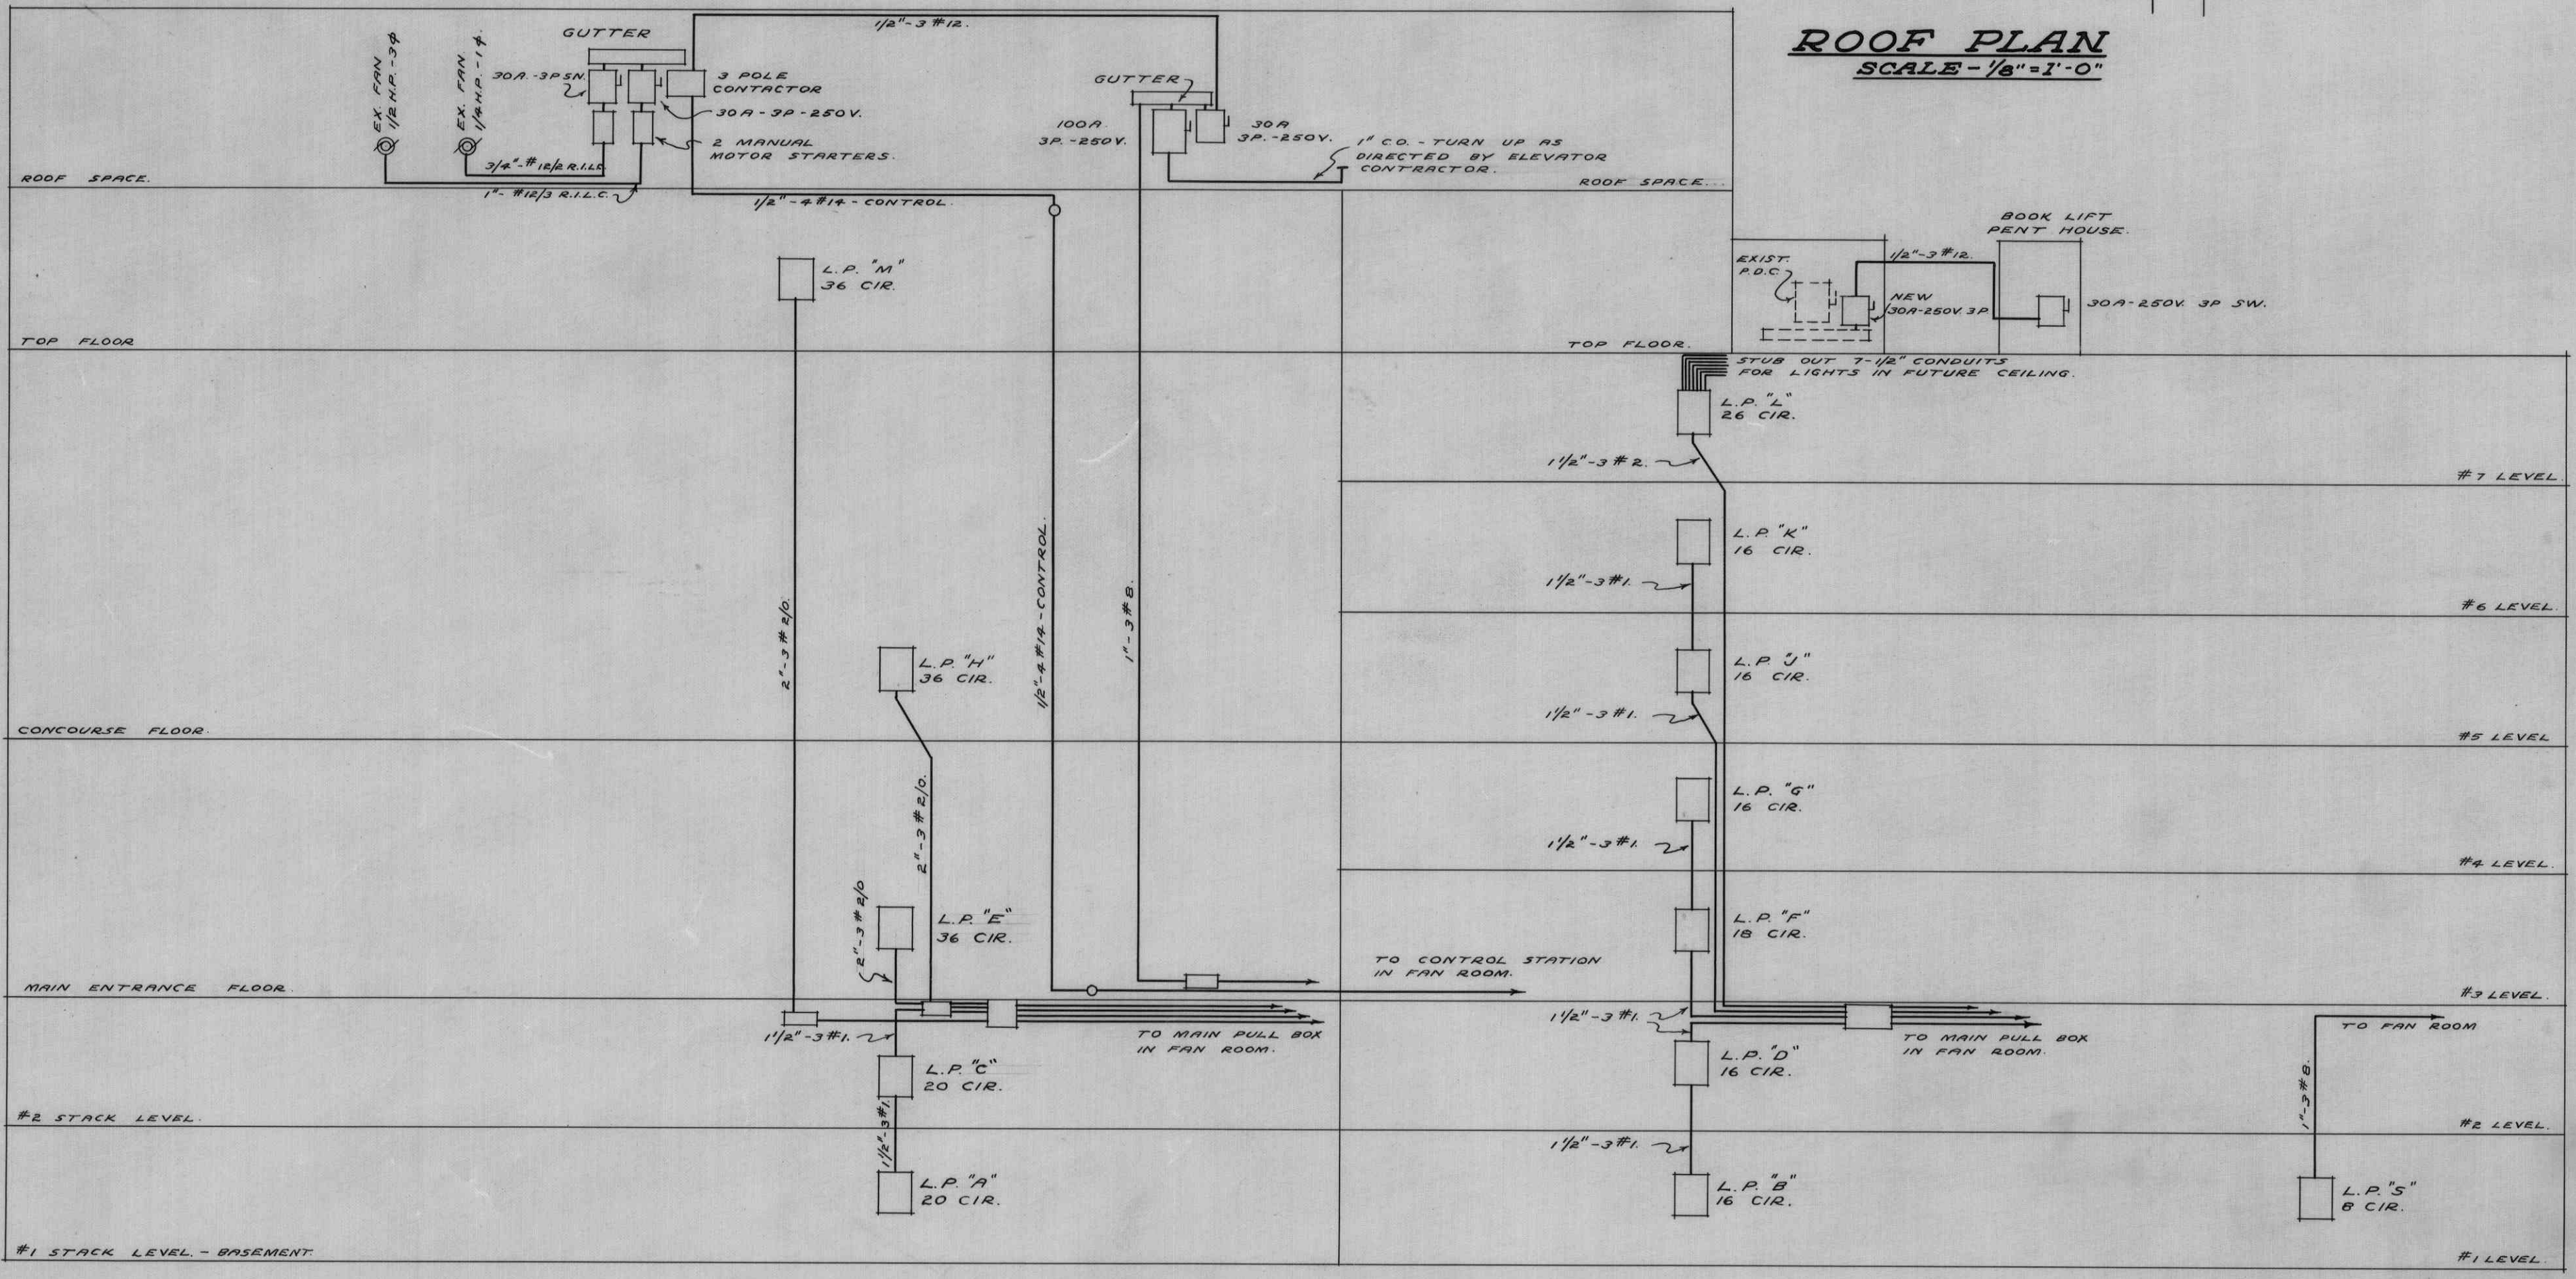

LIGHT & POWER RISER DIAGRAM
NOT TO SCALE

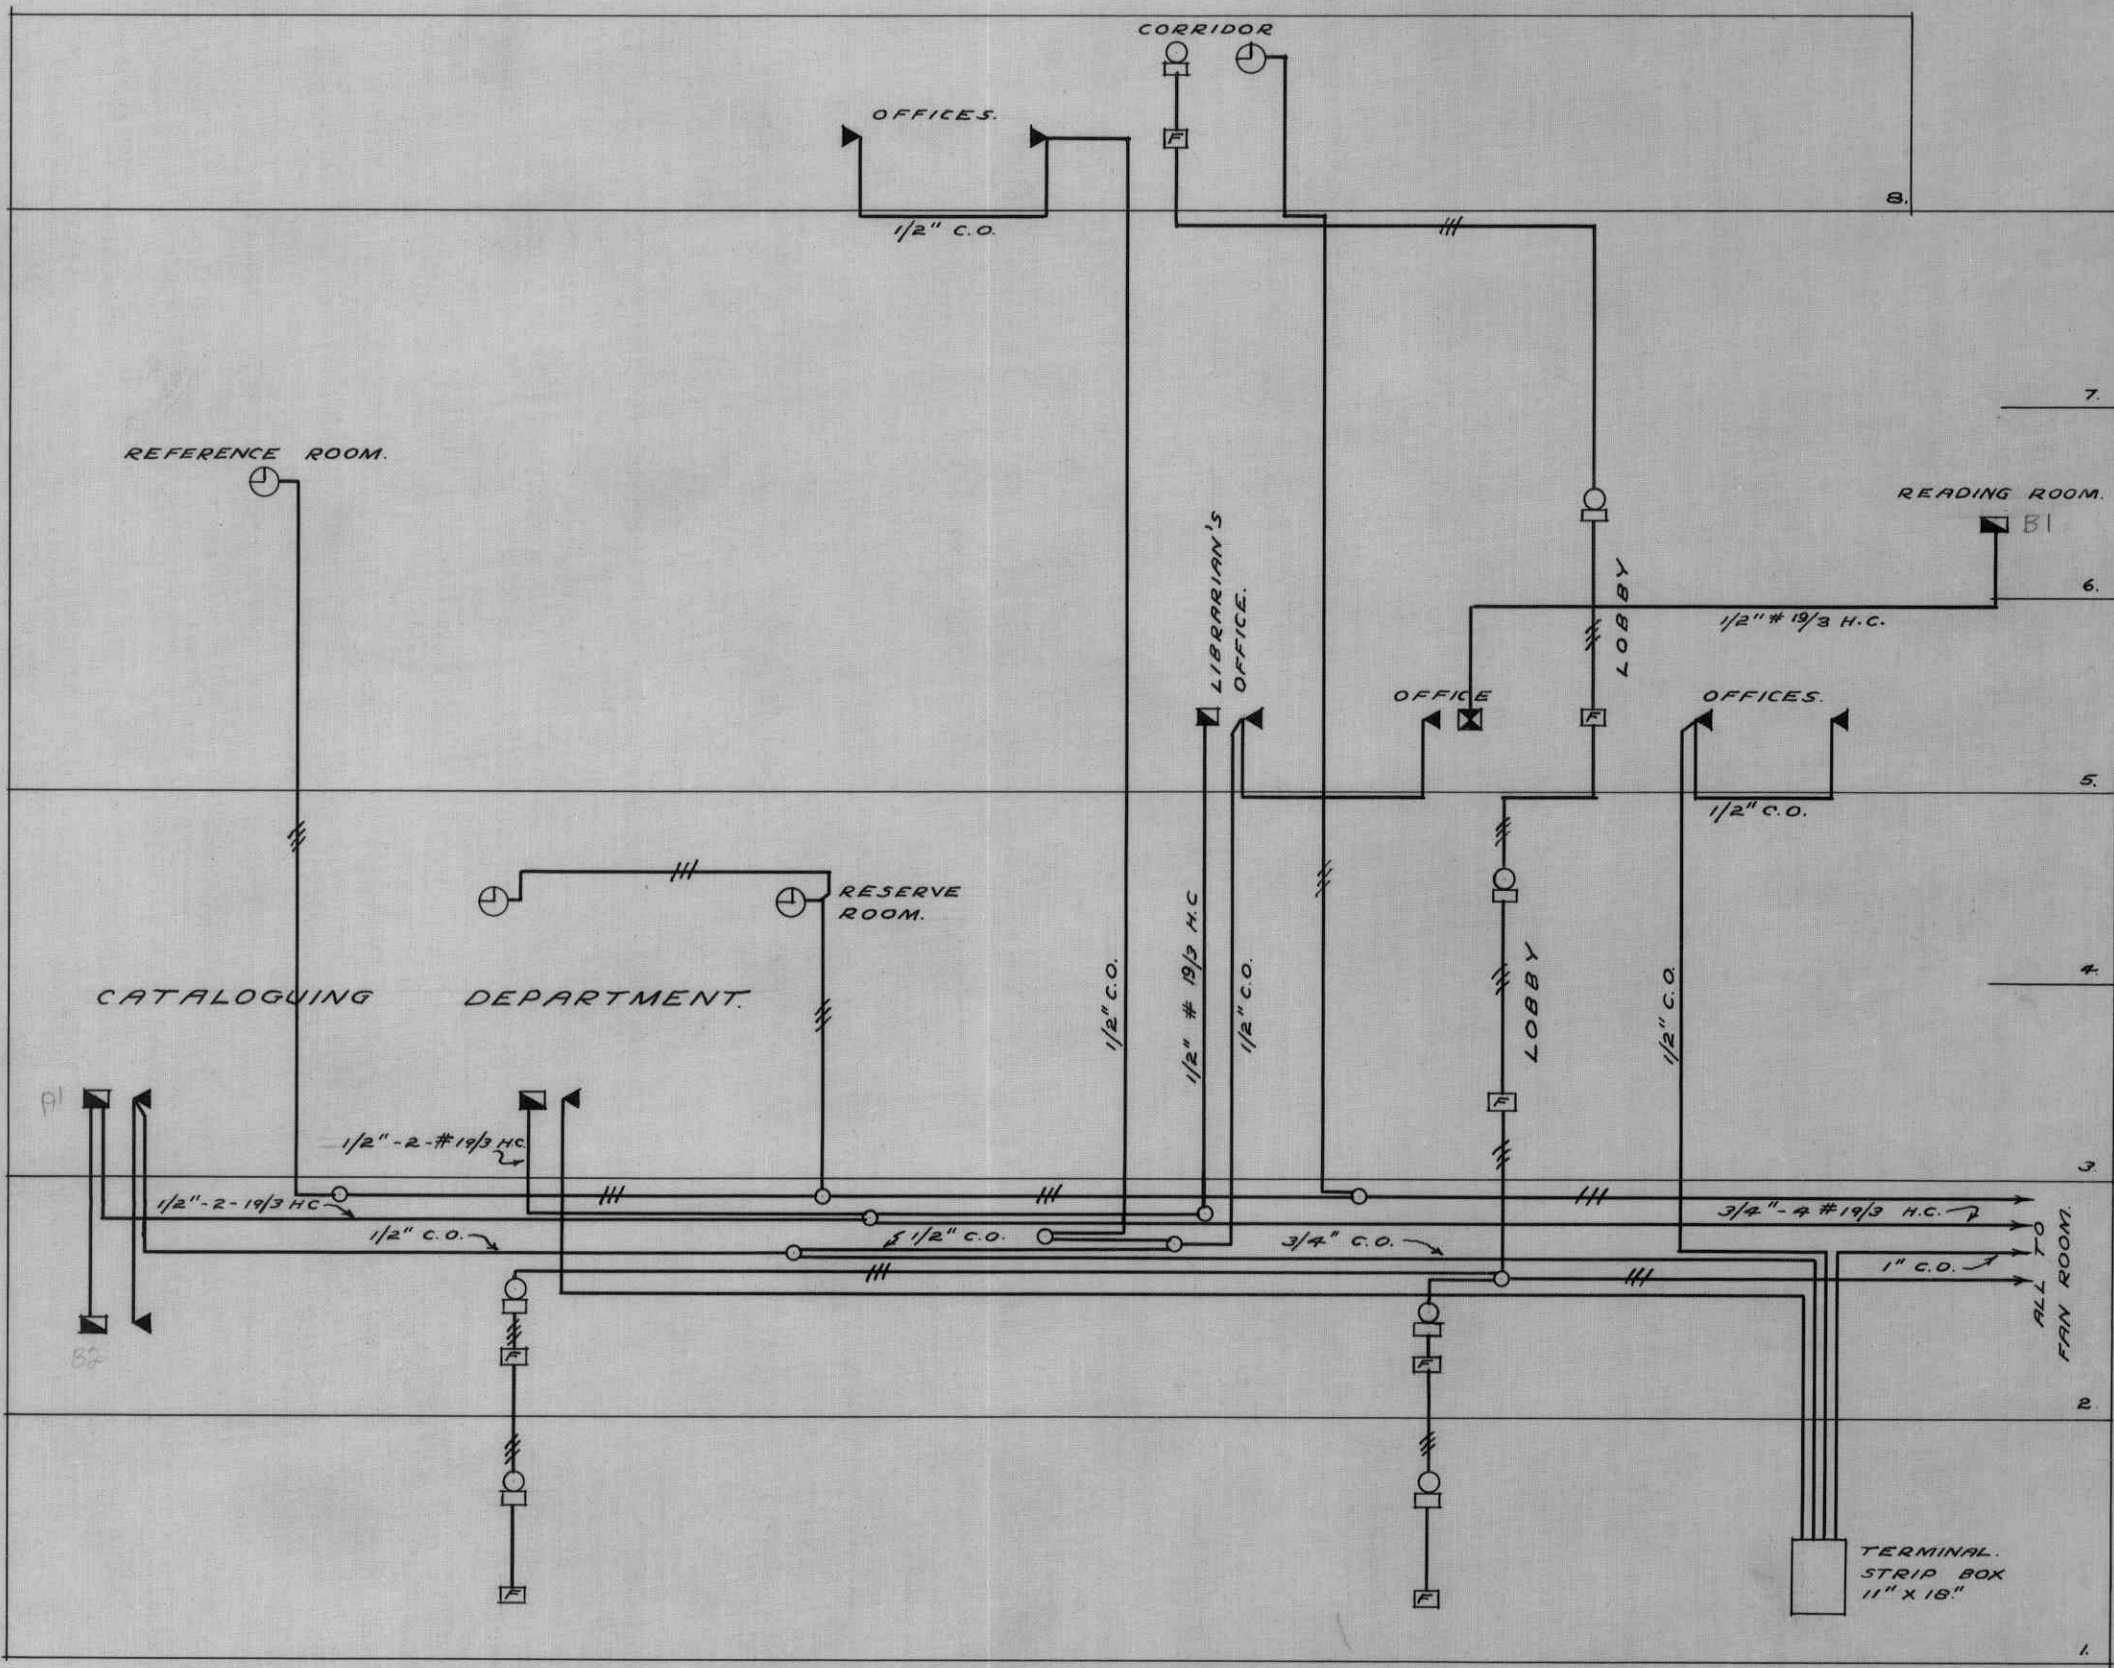

LOW TENSION RISER DIAGRAM
NOT TO SCALE

REVISION	DATE	ADDITION TO LIBRARY		SCALE
		UNIVERSITY	OF B. C.	AS NOTED
		A. EDWARD SIMPSON ELECTRICAL ENGINEER VANCOUVER, B. C.	SHARP & THOMPSON ARCHITECTS VANCOUVER, B. C.	DATE 25 JULY, 1946
				DRAWING NO. U2-5-8